

1 02 - PROPOSED ROOF PLAN

RWP

RWP

New Sprinkler Tank

RWP

RWP

RWP

 Drawn
 Checked
 Date Issued

 MW
 14/12/18

 MW
 18/01/19

 MW
 25/01/19

 JJ
 MW

 Rev
 Description

 P1
 First Issue

 P2
 Draft PAC Issue


 P3
 PAC Issue


 P4
 General Updates

RWP





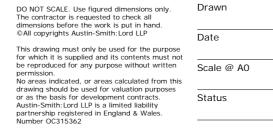

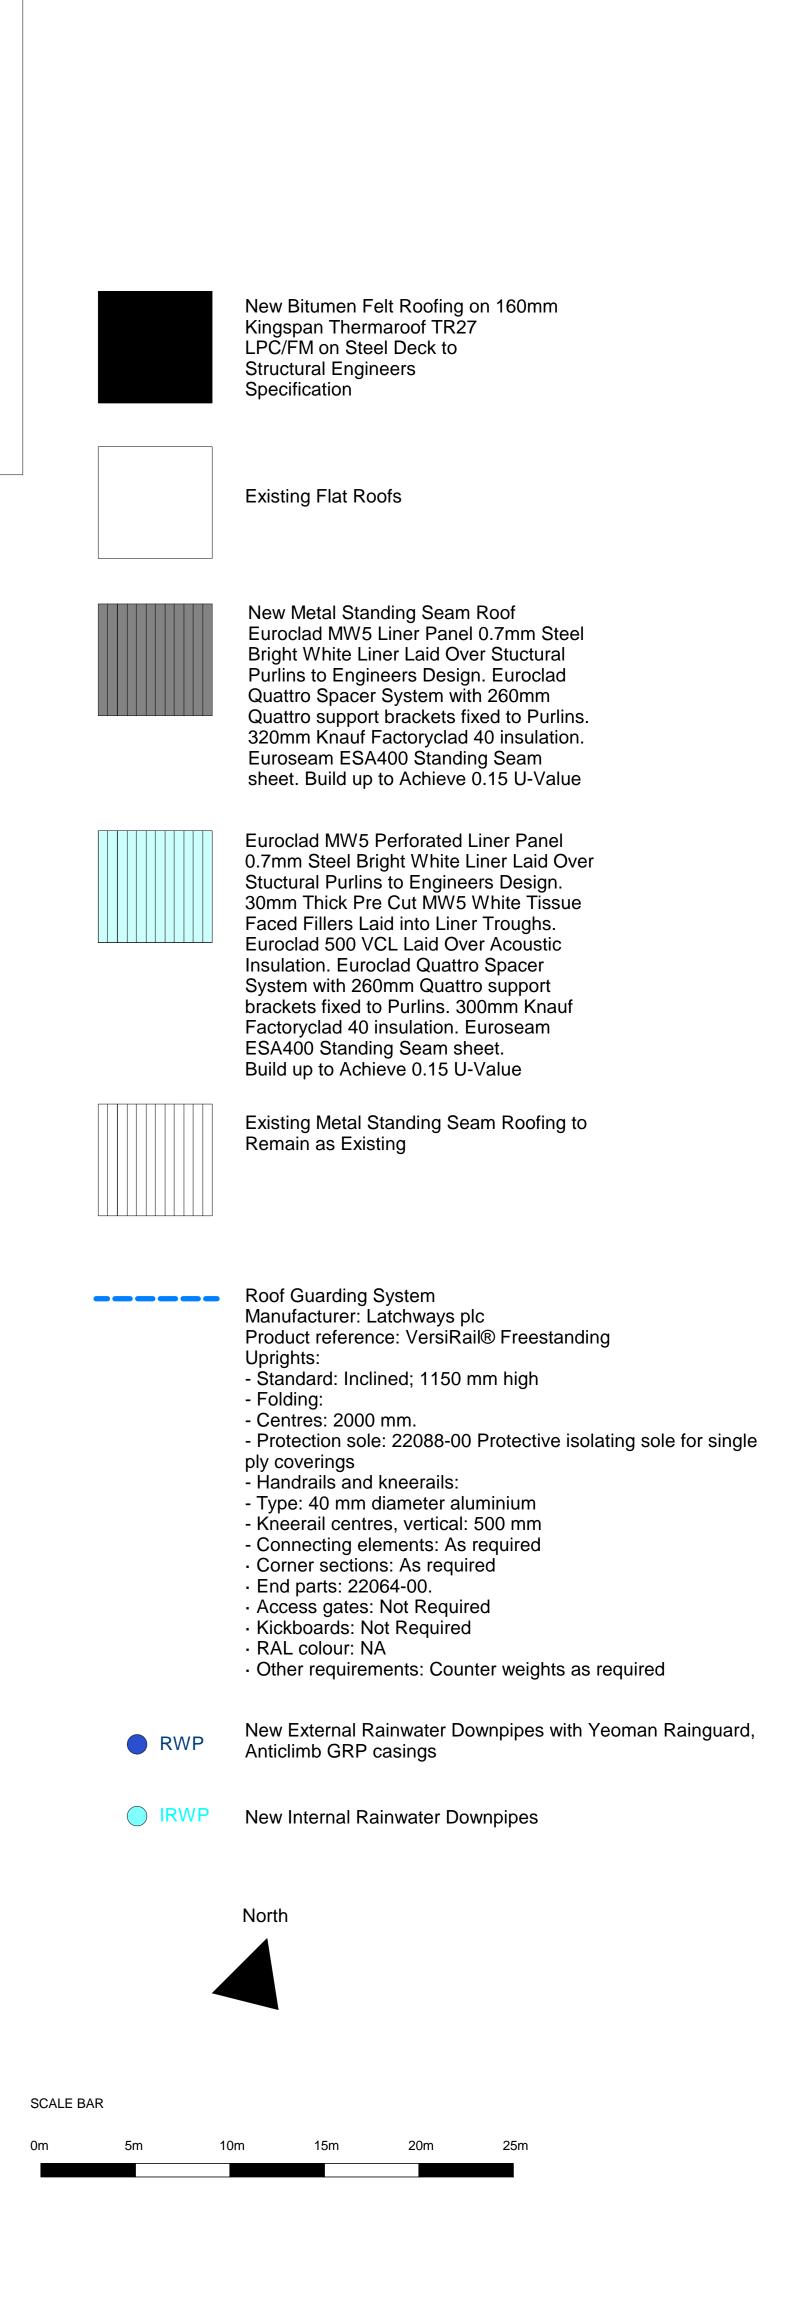

MW Austin-Smith:Lord LLP Architects Designers Planners

S2 e cardiff@austinsmithlord.com Drawings and models powered by Austin-Smith:Lord LLP BIM using AutoDesk Revit

Austin-Smith:Lord Project Ysgol Bro Morgannwg

Description Proposed Roof Plan Job No. Drawing No. Revision P4 _____